

EQUIPMENT SCHEDULE - CONCESSION / SERVING											
KEY	NAME	CONTRACTOR FURNISHED	CONTRACTOR INSTALLED	OWNER FURNISHED	OWNER INSTALLED	BASIS OF DESIGN	WIDTH	DEPTH	HEIGHT	QTY	NOTES
A4	BASE CABINET, METAL	•	•			CHEMTOPS	42	18	30	1	
A5	BASE CABINET, METAL	•	•			CHEMTOPS	24	24	34	3	
AC1	TRASH BIN			•	•	16 GAL. RUBBERMAID SLIM JIM H-2893	11	22	25	3	
AC2	RECYCLE BIN			•	•	16 GAL. RUBBERMAID SLIM JIM H-2893	11	22	25	3	
DW1	DISHWASHER	•	•			HUBERT HT-6	24.25	26	33.5	1	
FR1	REACH-IN SOLID SWING DOOR REFRIGERATOR	•	•			TRUE T-49-HC	54.125	29.5	78.375	2	
FR2	REACH-IN SOLID SWING DOOR FREEZER	•	•			TRUE T-12F-HC	24.875	23.125	63.125	1	
RF3	UNDERCOUNTER HALF CUBE ICE MACHINE	•	•			ADVANTO UC-H-160-A	26	27	38.1875	1	
RF4	3-DOOR BACK BAR COOLER	•	•			TRUE TB-4-HC	60.375	27.75	57	1	
RF5	SANDWICH/SALAD PREP TABLE	•	•			TRUE TSSU-60-16-HC	60.375	30.125	36.75	1	
RF6	PRESTIGE ICE CHEST	•	•			ADVANCE TABCO PRL-18-24-10-XD	24	20	36	2	
RF7	UNDERCOUNTER WINE COOLER	•	•			FRIGIDAIRE FRWW4543AS	21.5	27	34	1	
SK1	HAND SINK	•	•			ELKAY EHS-18-SSX	18	14.5	11	2	
SK2	PREF. SINK	•	•			PREPLINE XS1C-1818-L	38	23.5	43.75	1	
SK3	3-COMPARTMENT SINK W/ DRAINBOARD	•	•			PREPLINE XS3C-1416-R	56	21.5	43.75	1	
E7	SHelf	•	•			ADVANCE TABCO SS WS-18-84	60	18	16.5	2	Mounting Brackets Included
E8	SHelf	•	•			ADVANCE TABCO SS WS-18-144	96	18	16.5	2	Mounting Brackets Included
WT1	WORK TABLE	•	•			ADVANCE TABCO MSLAG-303-X	48	30	35.5	1	
SD	SOAP DISPENSER	•	•			BOBRICK R28917	4	4	12	2	
PTD	PAPER TOWEL DISPENSER	•	•			BOBRICK B9282	8.5	4	13.5	2	

INTERIOR ELEVATIONS LEGEND	
SYMBOL	DESCRIPTION
XX#	FINISH TAG - SEE A700s FOR FINISH LEGEND AND PLANS
XX##	EQUIPMENT TAG - SEE EQUIPMENT SCHEDULE
XX##	CASEWORK TAG - REFER TO SHEETS A550S FOR DETAILS
100	DOOR TAG - SEE SHEET A-600s AND FLOOR PLANS

GENERAL NOTES:
 1. RESIDENTIAL APPLIANCES TO BE OWNER FURNISHED CONTRACTOR INSTALLED
 A. MW - MICROWAVE
 B. REF - REFRIGERATOR
 C. DW - DISHWASHER
 2. G.C. TO COORDINATE ALL BLOCKING NEEDS FOR EACH SPECIFIC TOILET ACCESSORY OR EQUIPMENT ITEM PER MANUFACTURER'S RECOMMENDATIONS.
 G.G. TO PROVIDE BLOCKING FOR ALL OWNER PROVIDED EQUIPMENT.
 3. REFER TO A-410 FOR MOUNTING HEIGHTS
 4. REFER TO DETAILS AND SPECS FOR UNDERMOUNT DETAILS

...becoming the
 Leading Designer of
 High Performance Facilities
 in the Nation with a
 Specialty in Alternative
 Delivery Methods

333 Fayetteville St, Ste 235
 Raleigh, NC 27601
 P: 919.573.6500
 www.sfl+a.biz

sfl+a
 ARCHITECTS


ARCHITECTS
 CERT. NO.
 50876
 RALEIGH, NC

2/17/25


CONSTRUCTION SET/ IFC




11
 A407
 INTERIOR ELEVATION- SERVING PLAN EAST
 SCALE: 1/4" = 1'-0"

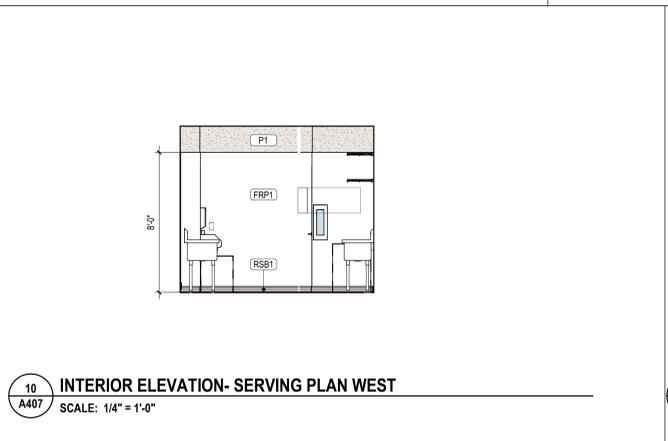


10
 A407
 INTERIOR ELEVATION- SERVING PLAN WEST
 SCALE: 1/4" = 1'-0"

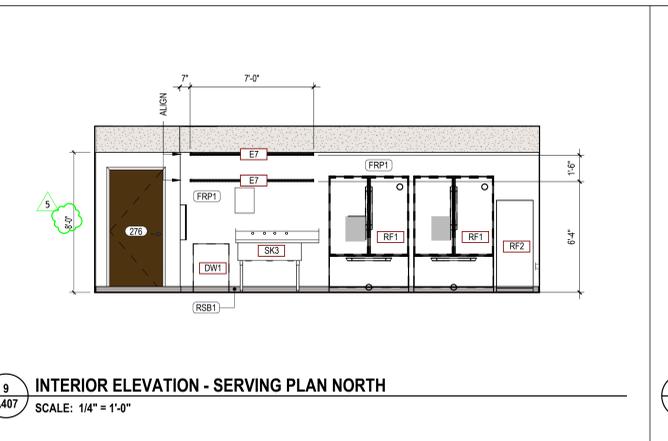


9
 A407
 INTERIOR ELEVATION - SERVING PLAN NORTH
 SCALE: 1/4" = 1'-0"

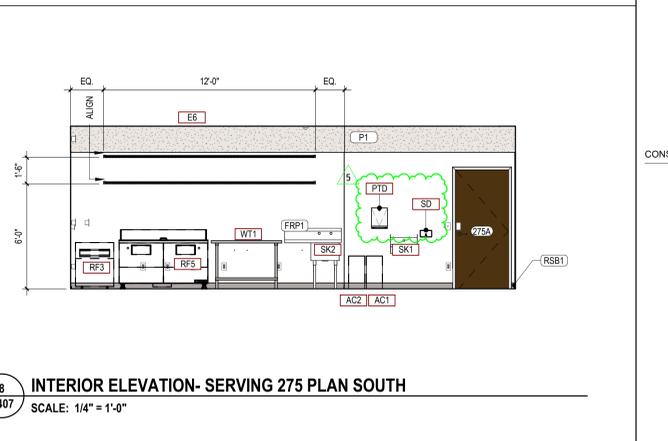


8
 A407
 INTERIOR ELEVATION- SERVING 275 PLAN SOUTH
 SCALE: 1/4" = 1'-0"

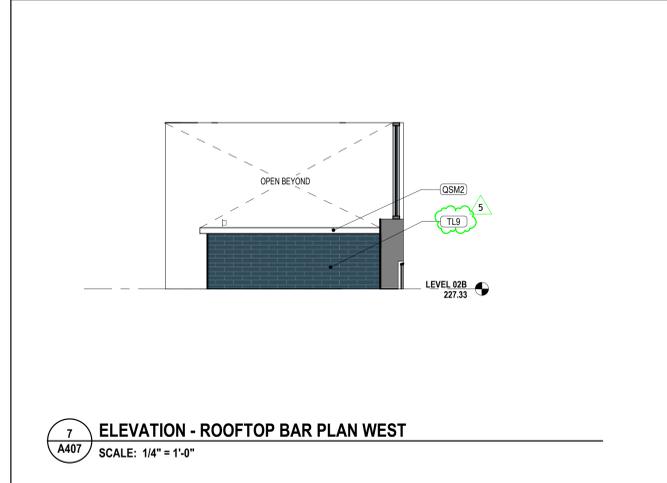

7
 A407
 ELEVATION - ROOFTOP BAR PLAN WEST
 SCALE: 1/4" = 1'-0"

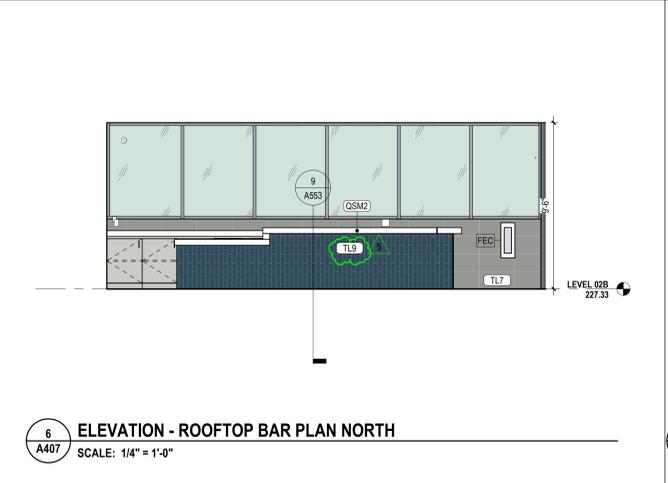

6
 A407
 ELEVATION - ROOFTOP BAR PLAN NORTH
 SCALE: 1/4" = 1'-0"

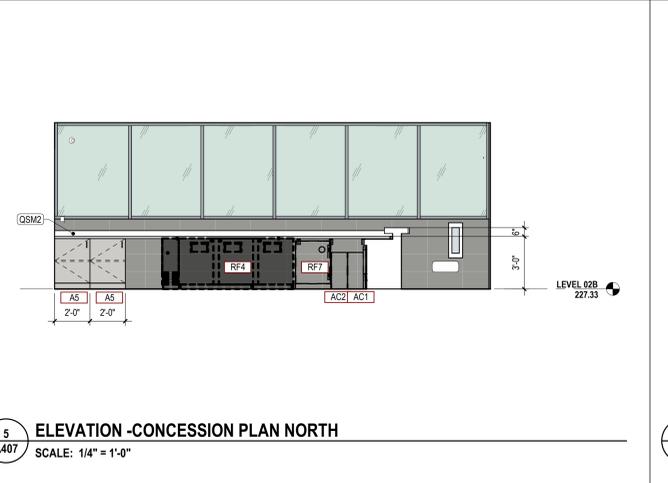


5
 A407
 ELEVATION - CONCESSION PLAN NORTH
 SCALE: 1/4" = 1'-0"




4
 A407
 ELEVATION-CONCESSION PLAN EAST
 SCALE: 1/4" = 1'-0"



3
 A407
 ELEVATION-CONCESSION PLAN WEST
 SCALE: 1/4" = 1'-0"

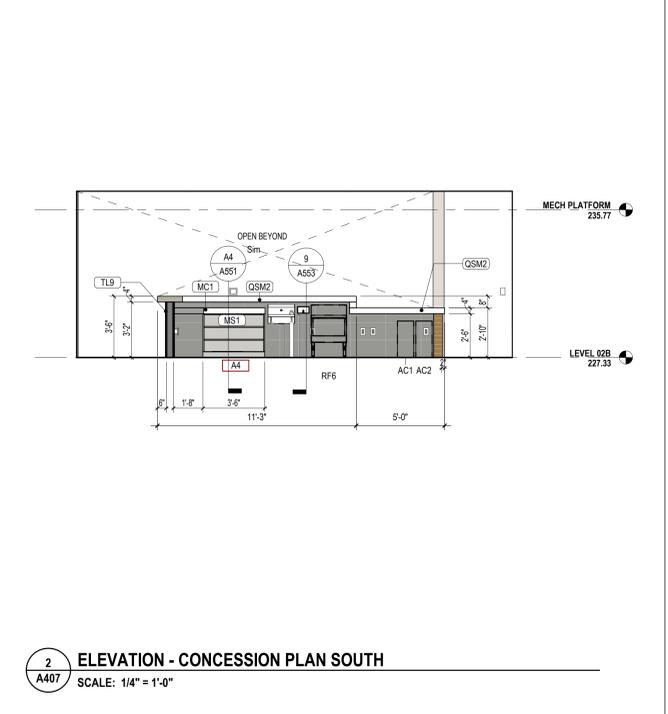

2
 A407
 ELEVATION - CONCESSION PLAN SOUTH
 SCALE: 1/4" = 1'-0"

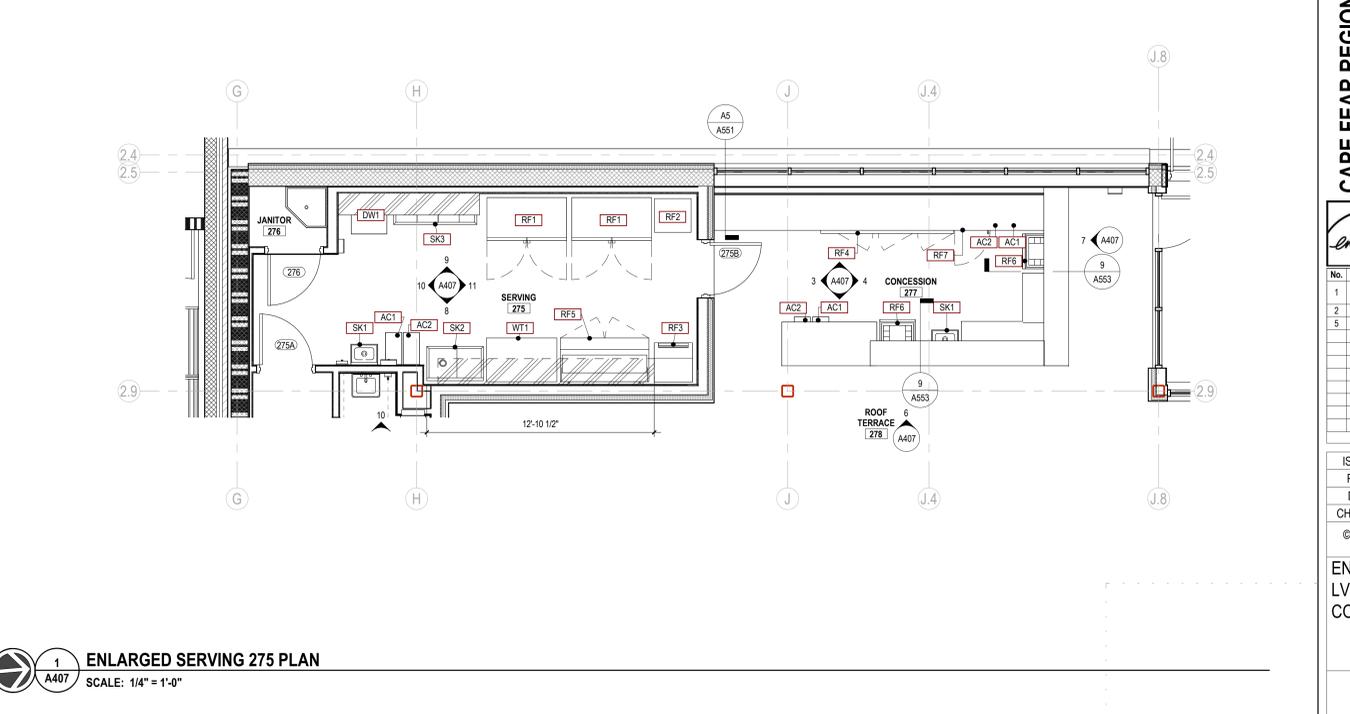

1
 A407
 ENLARGED SERVING 275 PLAN
 SCALE: 1/4" = 1'-0"

CAPE FEAR REGIONAL THEATRE RENOVATION AND EXPANSION
 1209 ARTS
 1209 HAY ST., FAYETTEVILLE, NC 28305

ENERGY STAR PARTNER

No.	Date	Description
1	10.18.24	Revision 1-Pricing Addendum
2	11.26.24	Addendum No2
5	03.05.25	IFC/VE Coordination

ISSUE DATE: 12/20/2024
 PROJECT #: 02020 603
 DRAWN BY: KB,DJ
 CHECKED BY: -

©2024 Sfl+a Architects, PA
 All Rights Reserved

ENLARGED PLANS -
 LVL 2 SERVING &
 CONCESSION

A407